




# EQUIPMENT SUPPORT CURB

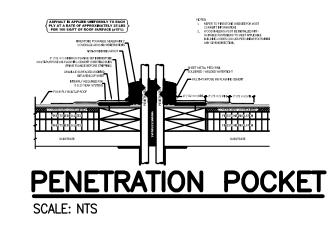

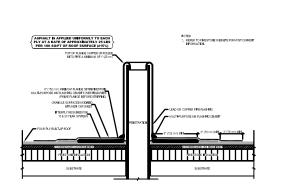

PLUMBING VENT
SCALE: NTS

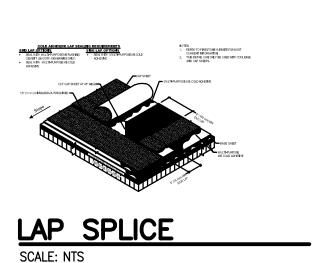

### **GENERAL ROOFING NOTES:**


- 1. THE CONTRACTOR IS TO VERIFY ALL CONDITIONS, DIMENSIONS, QUANTITIES, LOCATIONS, ETC. AND NOTIFY THE ARCHITECT OF ANY DISCREPANCIES PRIOR TO COMMENCEMENT OF WORK.
- 2. THE WORK OF THIS CONTRACT SHALL BE COMPLETED IN ACCORDANCE WITH THE ATTACHED DRAWINGS, DOCUMENTS, AND SPECIFICATIONS.
- 3. ALL MATERIALS TO BE USED ON THIS PROJECT SHALL BE INSTALLED IN STRICT CONFORMANCE WITH MANUFACTURE'S RECOMMENDED SPECIFICATIONS FOR INSTALLATION.
- 4. CONTRACTOR(S) SHALL COORDINATE THE WORK OF THIS CONTRACT TO AVOID ANY INTERFERENCE WITH ADJOINING AREAS.
- 5. ANY DEVIATIONS FROM THE ARCHITECT'S DRAWINGS MUST BE SUBMITTED TO THE ARCHITECT IN WRITING FOR APPROVAL, PRIOR TO COMMENCING SAME.
- 6. CONTRACTOR SHALL EXERCISE EXTREME CARE NOT TO DAMAGE THE ADJACENT CONSTRUCTION. ANY DAMAGE BY THE CONTRACTOR SHALL BE CORRECTED BY THE CONTRACTOR AT HIS OWN EXPENSE.
- 7. CONTRACTOR SHALL PROVIDE ALL SAFEGUARDS AS REQUIRED TO PRECLUDE INJURY TO OWNER'S AND
- 8. ROOFING MATERIAL TO BE PATCHED, REPAIRED AND REFLASHED AT THE NEW MECHANICAL COMPONENTS ONLY.Patching MUST BE BASED ON EXISTING ROOF SYSTEM.
- 9. ALL ROOF PIPE VENTS AND OTHER ROOF PENETRATION(S) SHALL BE EXTENDED UP AS REQ'D TO MAINTAIN
- A 6" MIN. (8" TYP) FLASHING HEIGHT ABOVE NEW TAPERED ROOF INSULATION.

CONTRACTOR'S PERSONNEL, AND TO ALL PERSONS AT THE CONSTRUCTION SITE.

# 10. PROVIDE PITCH POCKETS AT ALL ROOF PENETRATIONS

11. ALL WORK PERFORMED ON EXISTING ROOF SHALL BE DONE BY AN APPROVED ROOFING CONTRACTOR IN ORDER TO MAINTAIN EXIST. ROOFING WARRANTIES.

- 1. REFER TO MECHANICAL, ELECTRICAL, PLUMBING, AND STRUCTURAL DRAWINGS FOR PHASING SCHEDULE AND ADDITIONAL INFORMATION.
- 2. LOCATIONS OF DUCTWORK AND SUPPORTS TO BE COORDINATED W/ MECHANICAL AND STRUCTURAL SHOP DRAWINGS PRIOR TO INSTALLATION.

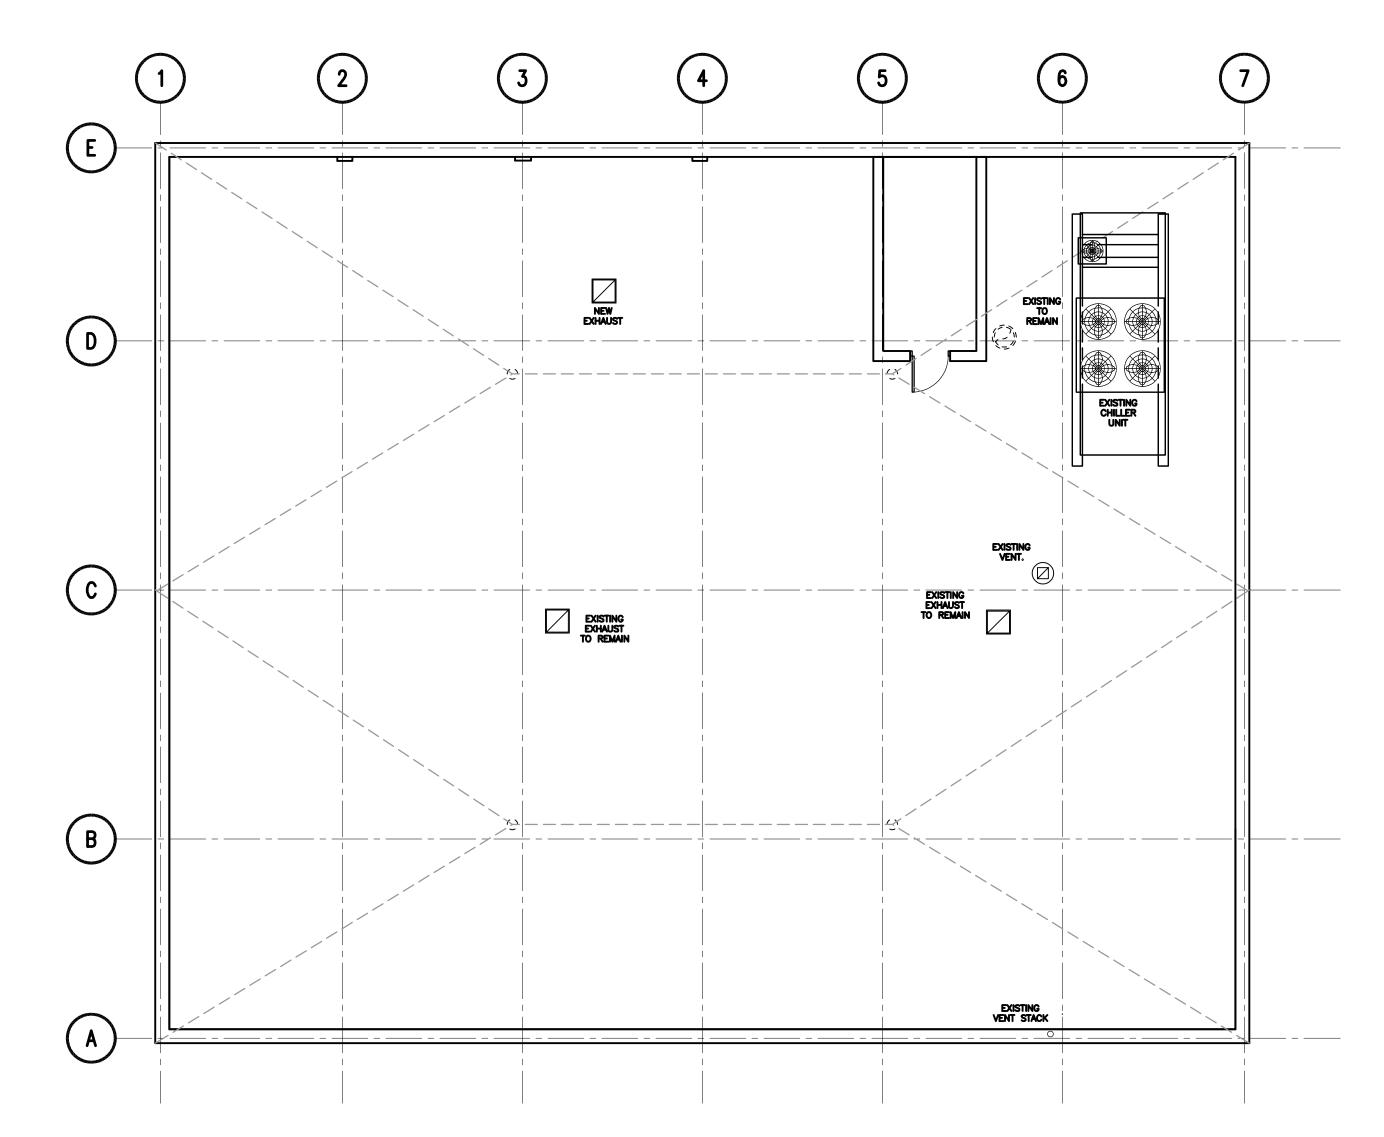

ROOF PLAN SCALE: 1/8" = 1'-0"



Stantec Consulting Services Inc. 100 Motor Parkway, Suite 420 Hauppauge, N.Y. 11788-4008 Tel. 631.424.8600 www.stantec.com

## Copyright Reserved

The Contractor shall verify and be responsible for all dimensions. DO NOT scale the drawing - any errors or omissions shall be reported to Stantec without delay. The Copyrights to all designs and drawings are the property of Stantec. Reproduction or use for any purpose other than that

Consultants

Phone: (631) 738-1200 Fax: (631) 285-6464 www.BohlerEngineering.com



Mechanical & Electrical Engineering 200 Old Country Road, Suite 670 Mineola, NY 11501 Phone: (516) 484-1020 Fax: (516) 484-0926

www.leapc.com AREA OF WORK 2,715 SQ FT

By Appd. YY.MM.DD Revision 
 GM
 BD
 23.10.16

 GM
 BD
 23.05.01

 GM
 BD
 22.12.09

 By
 Appd.
 YY.MM.DD
 OMEGA ENVIRONMENTAL SERVICES OMH FILING Issued File Name: 00004B\_A-131 - Roof Plan.dwg Dwn. Chkd. Dsgn. YY.MM.DD

Permit-Seal

Client/Project

RICHMOND UNIVERSITY MEDICAL CENTER TRANSFORMATION GRANT

669 CASTLETON AVE, STATEN ISLAND, NY SECOND FLOOR PROPOSED RENOVATION

ROOF PLAN AND TYPICAL ROOF DETAILS

Project No. Scale 225300004

Revision

1/4" = 1'-0"

Drawing No.