

212


TOILET 210

(ADA)

(NOT IN STAFF TOILET ROOMS #211 AND #222.) SEE FINISH SCHEDULE FOR FURTHER INFORMATION.


VISITOR TOILET 203


5 TOILET 210
SCALE: 1/4" = 1'-0"

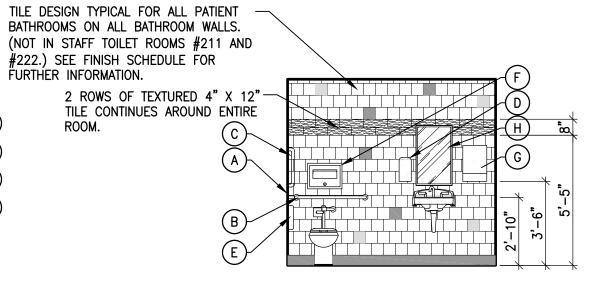

TOILET 210

VISITOR TOILET 203

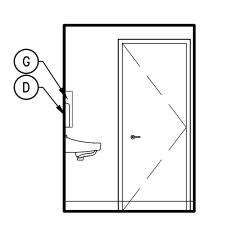

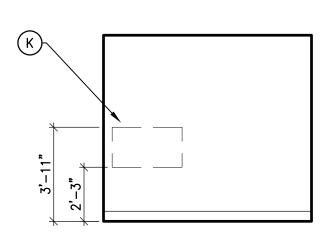

Hauppauge, N.Y. 11788-4008 Tel. 631.424.8600 www.stantec.com

Copyright Reserved

The Contractor shall verify and be responsible for all dimensions. DO NOT scale the drawing - any errors or omissions shall be reported to Stantec without delay. The Copyrights to all designs and drawings are the property of Stantec. Reproduction or use for any purpose other than that


Consultants


BOHLER//


authorized by Stantec is forbidden.

2929 Expressway Drive North Hauppauge, NY 11749 Phone: (631) 738-1200

Mechanical & Electrical Engineering 200 Old Country Road, Suite 670

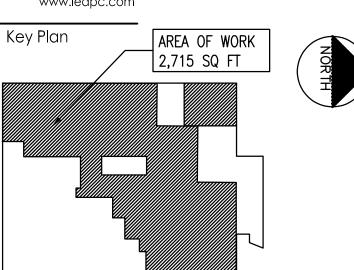


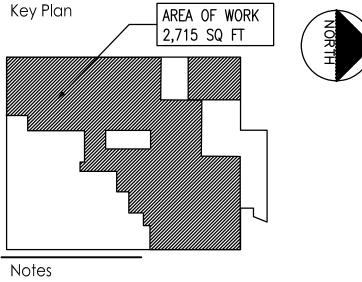

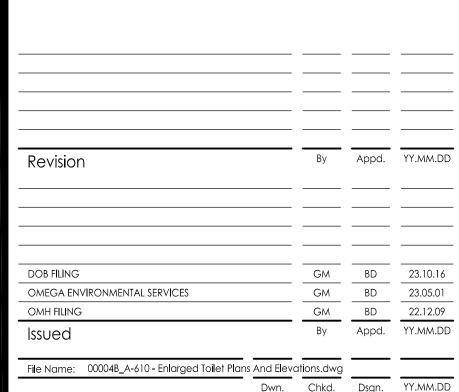

www.BohlerEngineering.com

Mineola, NY 11501

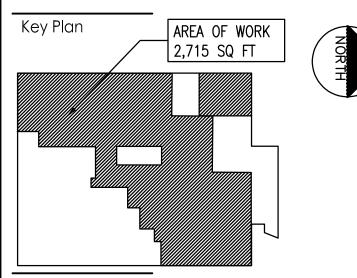

Fax: (631) 285-6464

Phone: (516) 484-1020 Fax: (516) 484-0926 www.leapc.com

File Name: 00004B_A-610 - Enlarged Toilet Plans And Elevations.dwg

Dwn. Chkd. Dsgn. YY.MM.DD

Permit-Seal

Client/Project

RICHMOND UNIVERSITY MEDICAL CENTER TRANSFORMATION GRANT

669 CASTLETON AVE, STATEN ISLAND, NY SECOND FLOOR PROPOSED RENOVATION

SECOND FLOOR ENLARGED TOILET PLANS AND ELEVATIONS


Scale

A-610.00


Stantec Consulting Services Inc. 100 Motor Parkway, Suite 420


VISITOR TOILET 203


TOILET 210

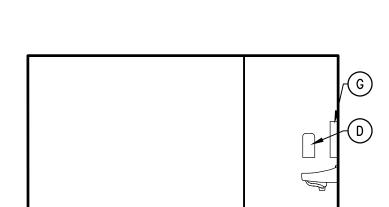



VISITOR TOILET 203

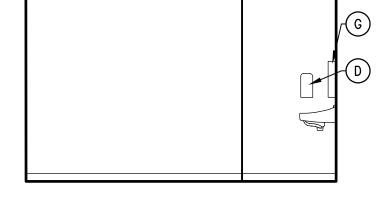


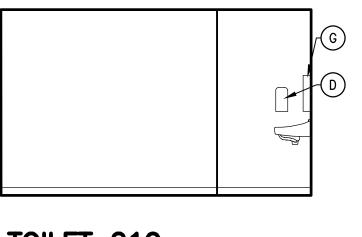


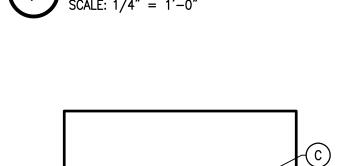


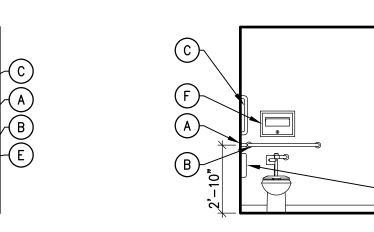


  


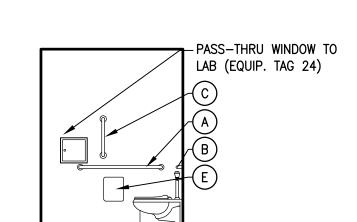


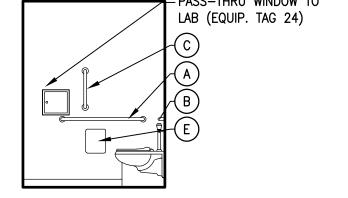




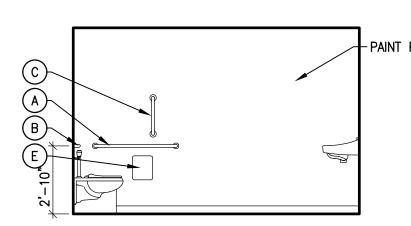

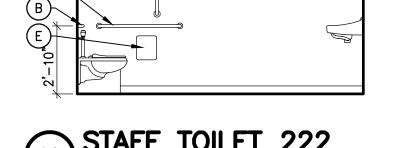

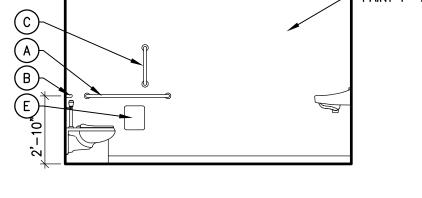

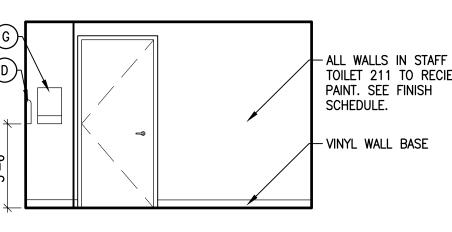

PATIENT TOILET 224


SCALE: 1/4" = 1'-0"

STAFF TOILET 222

SCALE: 1/4" = 1'-0"

- ALL WALLS IN STAFF TOILET 211 TO RECIEVE PAINT. SEE FINISH SCHEDULE.

- VINYL WALL BASE

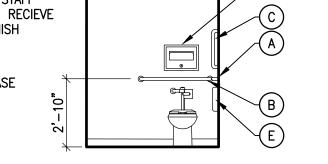



PATIENT TOILET 224

SCALE: 1/4" = 1'-0"

3 ENLARGED PARTIAL PLAN SCALE: 1/2"=1'-0" PLUMBING SCHEDULE

2 ENLARGED PARTIAL PLAN
SCALE: 1/2"=1'-0"

1 ENLARGED PARTIAL PLAN
SCALE: 1/2"=1'-0"

TAG NO.	DESCRIPTION	MANUFACTURER	MODEL	PROVIDED BY	INSTALLED BY
Α	48" STAINLESS STEEL GRAB BAR	BOBRICK WASHROOM EQUIPMENT, INC.	B-6806	CONTRACTOR	CONTRACTOR
В	42" STAINLESS STEEL GRAB BAR	BOBRICK WASHROOM EQUIPMENT, INC.	B-6806	CONTRACTOR	CONTRACTOR
С	18" STAINLESS STEEL GRAB BAR	BOBRICK WASHROOM EQUIPMENT, INC.	B-6806	CONTRACTOR	CONTRACTOR
D	SOAP DISPENSER	RUMC STANDARD		OWNER	CONTRACTOR
Е	SURFACE-MOUNTED TOILET TISSUE DISPENSER	RUMC STANDARD		OWNER	CONTRACTOR
F	SURFACE MOUNTED SEAT COVER DISPENSER	BOBRICK WASHROOM EQUIPMENT, INC.	B-4221	OWNER	CONTRACTOR
G	SURFACE MOUNTED PAPER TOWEL DISPENSER	RUMC STANDARD		OWNER	CONTRACTOR
Н	MIRROR	BOBRICK WASHROOM EQUIPMENT, INC.	B-2908 SERIES; 2'x3'	CONTRACTOR	CONTRACTOR
1	WALL MOUNTED SINK	SEE PLUMBING DRAWINGS		CONTRACTOR	CONTRACTOR
J	PIPING SHIELD	SEE PLUMBING DRAWINGS		CONTRACTOR	CONTRACTOR
K	CHANGING TABLE	KOALA CARE	KB200 COLOR: 05SS	CONTRACTOR	CONTRACTOR
L	FLOOR MOUNTED TOILET	SEE PLUMBING DRAWINGS		CONTRACTOR	CONTRACTOR

TOILET 211 TO RECIEVE



19 STAFF TOILET 222

SCALE: 1/4" = 1'-0"

STAFF TOILET 222

SCALE: 1/4" = 1'-0"

-PAINT P-1

PATIENT TOILET 224

SCALE: 1/4" = 1'-0"

225300004

Drawing No.

AS NOTED Sheet

Revision

21 of 22

ORIGINAL SHEET - ARCH D